


Presentation of Concept Design - Option A



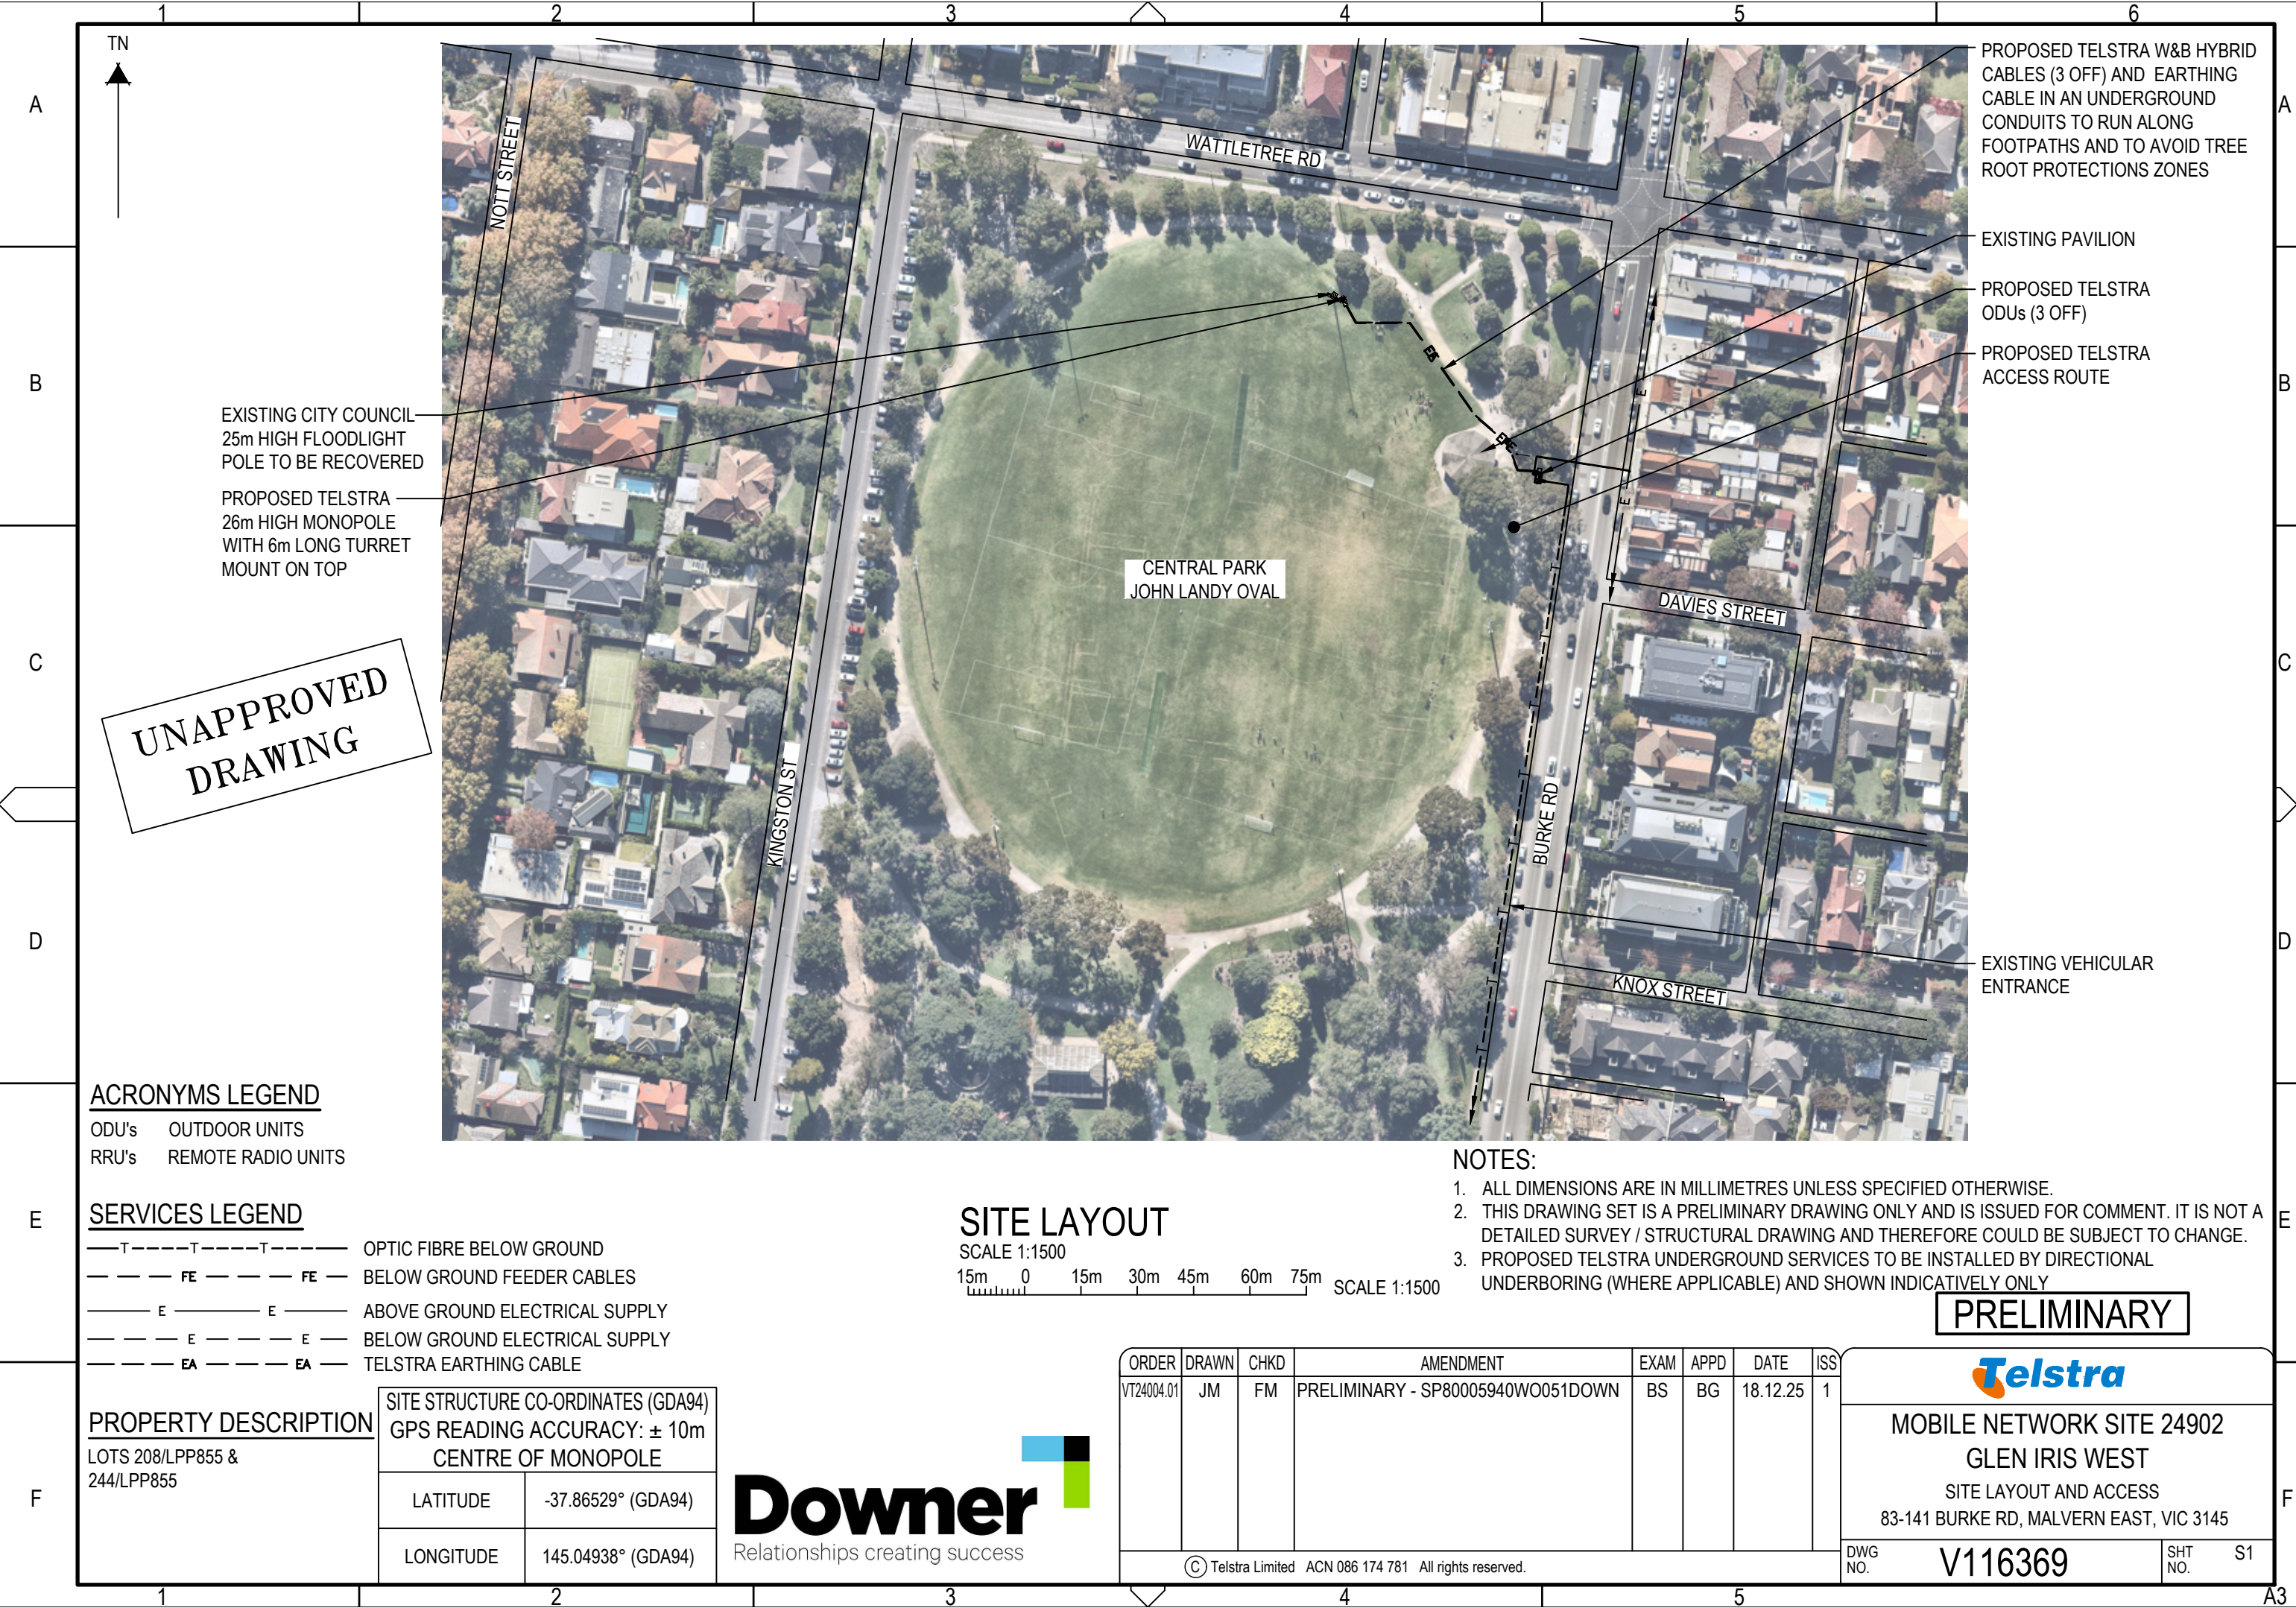

UNAPPROVED
DRAWING

ACRONYMS LEGEND

ODU's OUTDOOR UNITS
RRU's REMOTE RADIO UNITS

SERVICES LEGEND

— T — — — — T — — — — T — — — — OPTIC FIBRE BELOW GROUND
— — — — FE — — — — FE — — — — BELOW GROUND FEEDER CABLES
— — — — E — — — — E — — — — ABOVE GROUND ELECTRICAL SUPPLY
— — — — E — — — — E — — — — BELOW GROUND ELECTRICAL SUPPLY
— — — — EA — — — — EA — — — — TELSTRA EARTHING CABLE


PROPERTY DESCRIPTION

LOTS 208/LPP855 &
244/LPP855

SITE STRUCTURE CO-ORDINATES (GDA94) GPS READING ACCURACY: ± 10m CENTRE OF MONOPOLE	
LATITUDE	-37.86529° (GDA94)
LONGITUDE	145.04938° (GDA94)



 SITE LAYOUT



NOTES:


1. ALL DIMENSIONS ARE IN MILLIMETRES UNLESS SPECIFIED OTHERWISE.
2. THIS DRAWING SET IS A PRELIMINARY DRAWING ONLY AND IS ISSUED FOR COMMENT. IT IS NOT A DETAILED SURVEY / STRUCTURAL DRAWING AND THEREFORE COULD BE SUBJECT TO CHANGE.
3. PROPOSED TELSTRA UNDERGROUND SERVICES TO BE INSTALLED BY DIRECTIONAL UNDERBORING (WHERE APPLICABLE) AND SHOWN INDICATIVELY ONLY

PRELIMINARY

ORDER	DRAWN	CHKD	AMENDMENT	EXAM	APPD	DATE	ISS
VT24004.01	JM	FM	PRELIMINARY - SP80005940WO051DOWN	BS	BG	18.12.25	1
© Telstra Limited ACN 086 174 781 All rights reserved.							

MOBILE NETWORK SITE 24902
GLEN IRIS WEST
SITE LAYOUT AND ACCESS
83-141 BURKE RD, MALVERN EAST, VIC 3145

DWG NO. **V116369** SHT NO. S1

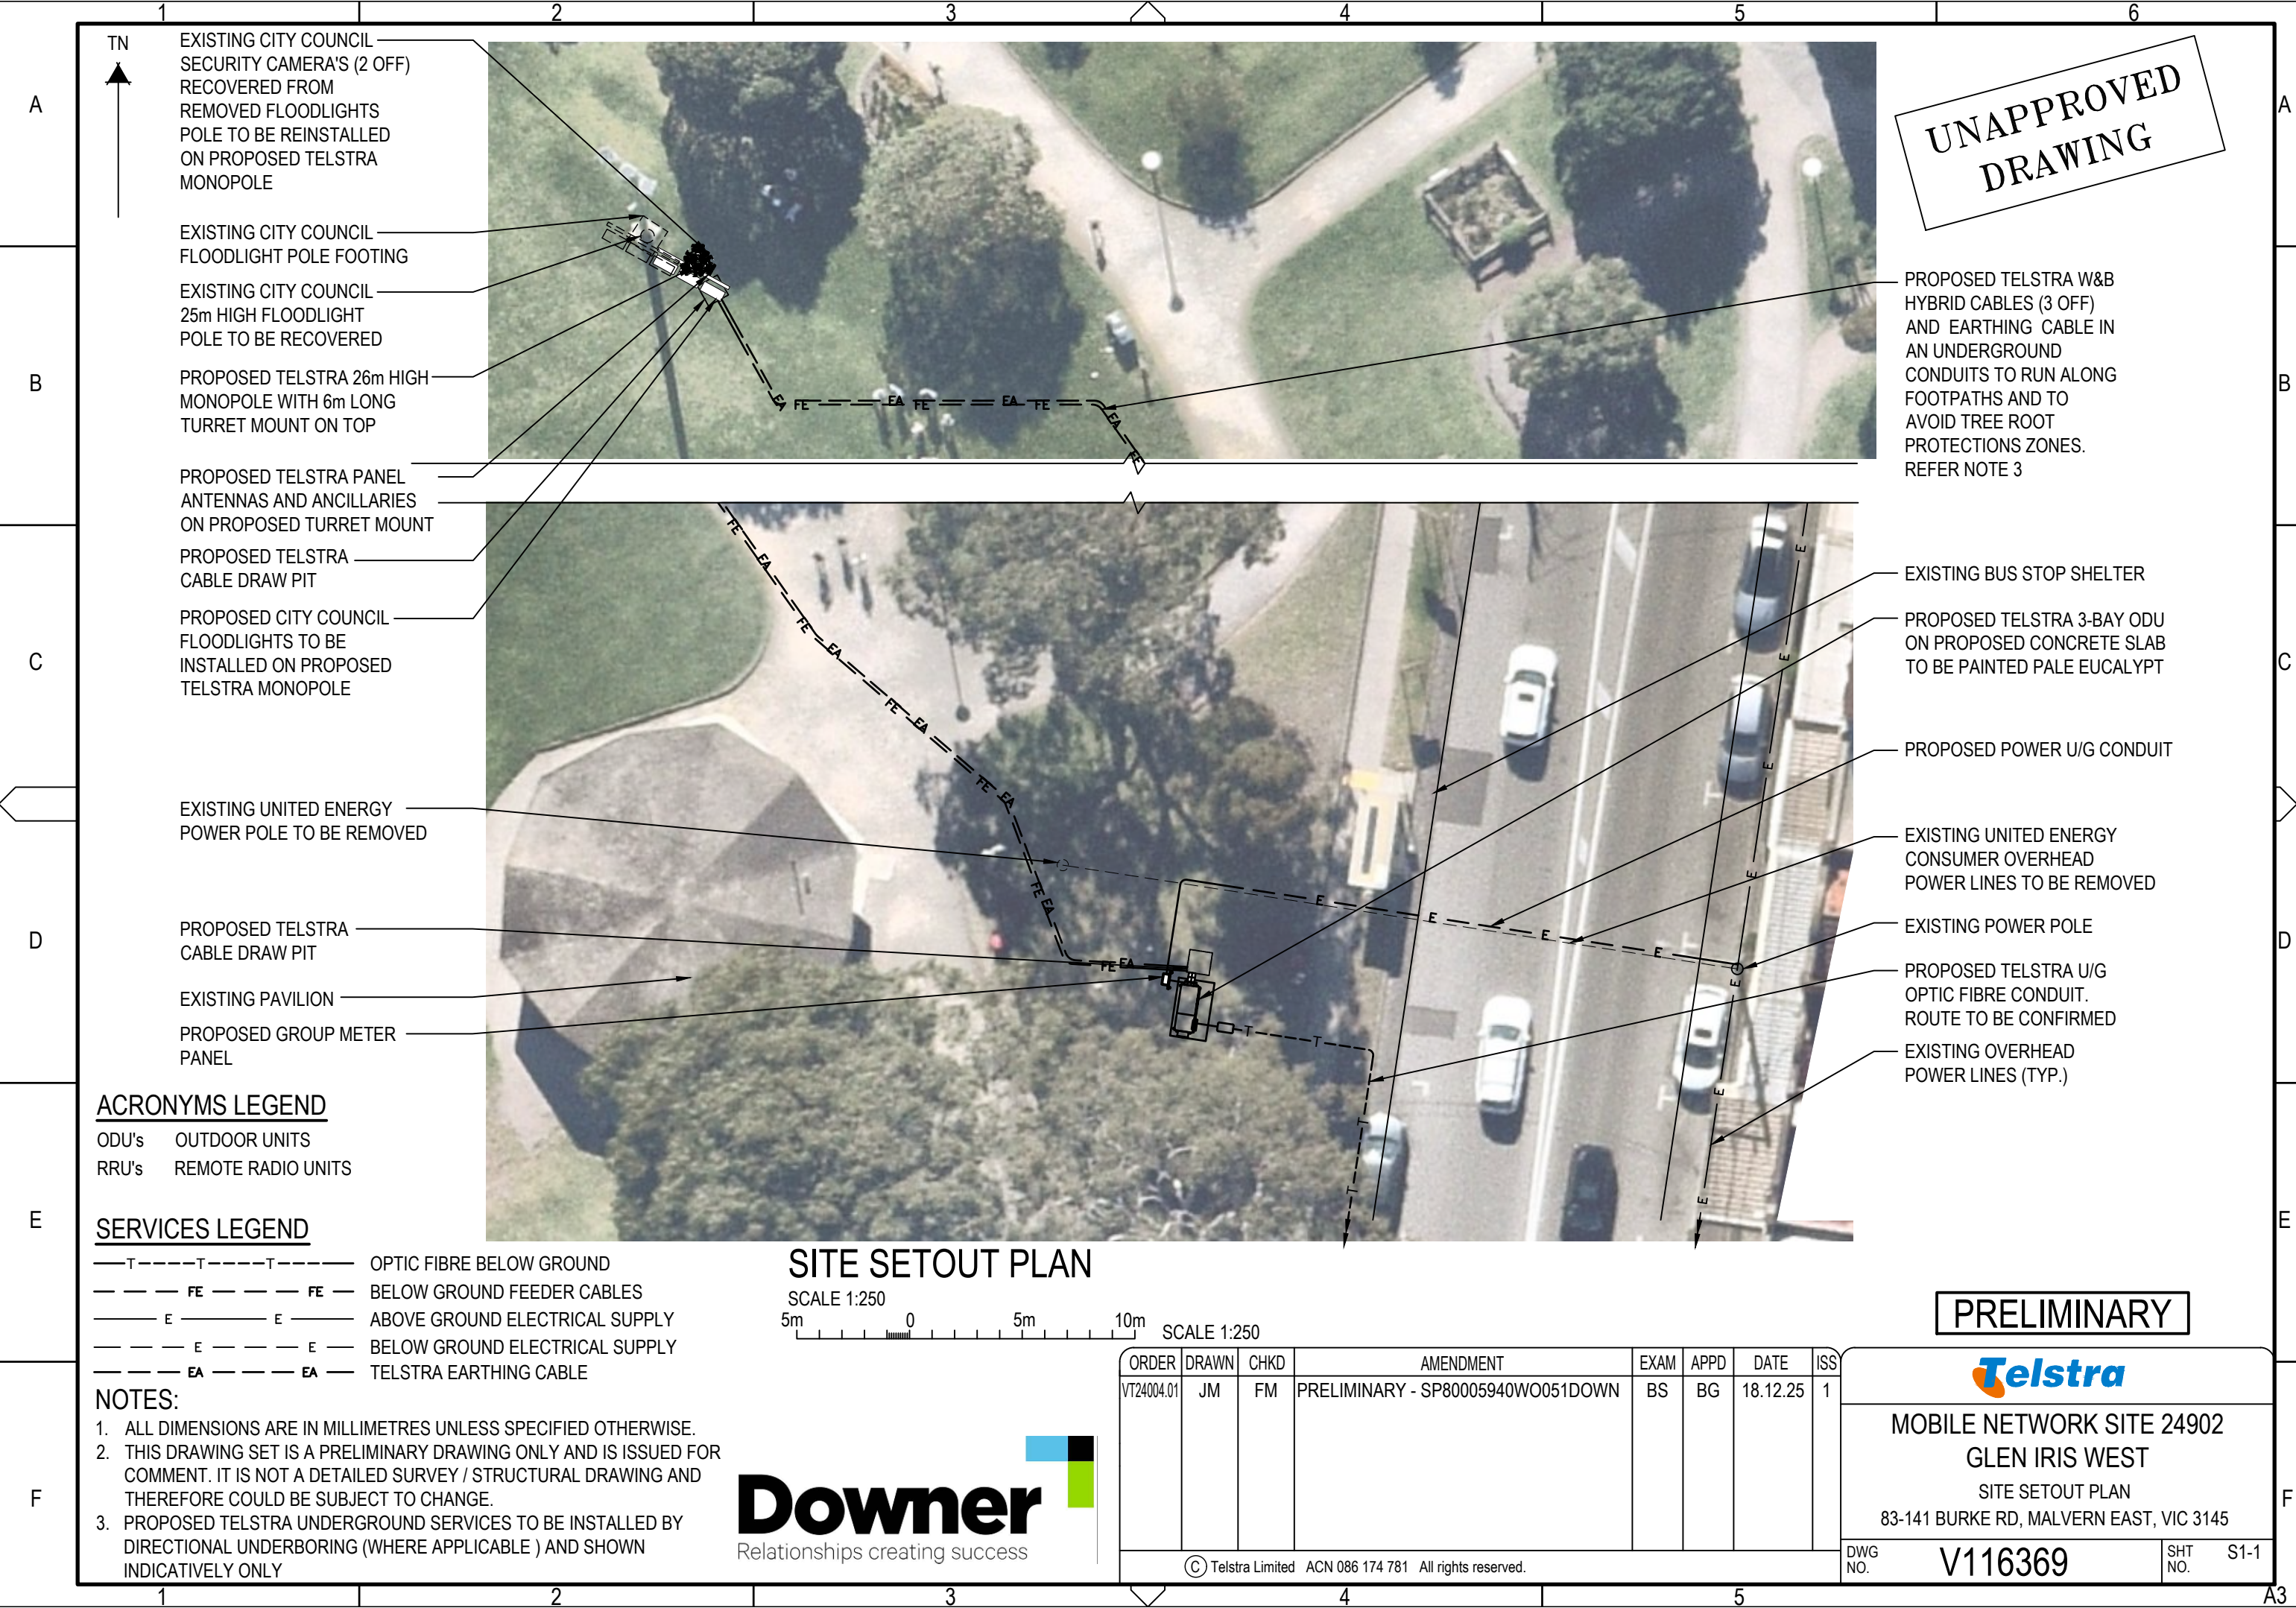

UNAPPROVED
DRAWING

PROPOSED TELSTRA W&B
HYBRID CABLES (3 OFF)
AND EARTHING CABLE IN
AN UNDERGROUND
CONDUITS TO RUN ALONG
FOOTPATHS AND TO
AVOID TREE ROOT
PROTECTIONS ZONES.
REFER NOTE 3

EXISTING BUS STOP SHELTER
PROPOSED TELSTRA 3-BAY ODU
ON PROPOSED CONCRETE SLAB
TO BE PAINTED PALE EUCALYPT
PROPOSED POWER U/G CONDUIT
EXISTING UNITED ENERGY
CONSUMER OVERHEAD
POWER LINES TO BE REMOVED
EXISTING POWER POLE
PROPOSED TELSTRA U/G
OPTIC FIBRE CONDUIT.
ROUTE TO BE CONFIRMED
EXISTING OVERHEAD
POWER LINES (TYP.)

ACRONYMS LEGEND

ODU's OUTDOOR UNITS
RRU's REMOTE RADIO UNITS

SERVICES LEGEND

—T—T—T— OPTIC FIBRE BELOW GROUND
— FE — FE — BELOW GROUND FEEDER CABLES
— E — E — ABOVE GROUND ELECTRICAL SUPPLY
— E — E — BELOW GROUND ELECTRICAL SUPPLY
— EA — EA — TELSTRA EARTHING CABLE

NOTES:

1. ALL DIMENSIONS ARE IN MILLIMETRES UNLESS SPECIFIED OTHERWISE.
2. THIS DRAWING SET IS A PRELIMINARY DRAWING ONLY AND IS ISSUED FOR COMMENT. IT IS NOT A DETAILED SURVEY / STRUCTURAL DRAWING AND THEREFORE COULD BE SUBJECT TO CHANGE.
3. PROPOSED TELSTRA UNDERGROUND SERVICES TO BE INSTALLED BY DIRECTIONAL UNDERBORING (WHERE APPLICABLE) AND SHOWN INDICATIVELY ONLY

SITE SETOUT PLAN

SCALE 1:250
5m 0 5m 10m SCALE 1:250



PRELIMINARY



MOBILE NETWORK SITE 24902
GLEN IRIS WEST
SITE SETOUT PLAN
83-141 BURKE RD, MALVERN EAST, VIC 3145

ORDER	DRAWN	CHKD	AMENDMENT	EXAM	APPD	DATE	ISS
VT24004.01	JM	FM	PRELIMINARY - SP80005940WO051DOWN	BS	BG	18.12.25	1

© Telstra Limited ACN 086 174 781 All rights reserved.

DWG
NO.

V116369

SHT
NO.

S1-1

NOTES:

1. ALL DIMENSIONS ARE IN MILLIMETRES UNLESS SPECIFIED OTHERWISE.
2. THIS DRAWING SET IS A PRELIMINARY DRAWING ONLY AND IS ISSUED FOR COMMENT. IT IS NOT A DETAILED SURVEY / STRUCTURAL DRAWING AND THEREFORE COULD BE SUBJECT TO CHANGE.
3. PROPOSED TELSTRA UNDERGROUND SERVICES TO BE INSTALLED BY DIRECTIONAL UNDERBORING (WHERE APPLICABLE) AND SHOWN INDICATIVELY ONLY

PROPOSED TELSTRA 6m LONG
TURRET MOUNT

EXISTING CITY COUNCIL
FLOODLIGHTS TO BE RECOVERED

PROPOSED CITY COUNCIL
FLOODLIGHTS TO BE INSTALLED ON
PROPOSED TELSTRA MONOPOLE

EXISTING CITY COUNCIL 25m HIGH
FLOODLIGHT POLE TO BE RECOVERED

PROPOSED TELSTRA W&B HYBRID
CABLES TO RUN INTERNAL TO
PROPOSED MONOPOLE

PROPOSED TELSTRA 26m HIGH
MONOPOLE WITH 6m LONG
TURRET MOUNT ON TOP

EXISTING CITY COUNCIL SECURITY
CAMERA'S (2 OFF) RECOVERED
FROM REMOVED FLOODLIGHTS
POLE TO BE REINSTALLED ON
PROPOSED TELSTRA MONOPOLE
(BEHIND)

PROPOSED TELSTRA W&B HYBRID
CABLES (3 OFF) TO RUN IN
UNDERGROUND CONDUIT. REFER
NOTE 3

PROPOSED TELSTRA EARTHING CABLE
IN AN UNDERGROUND CONDUIT. REFER
NOTE 3

PROPOSED TELSTRA 150mm CABLE
LADDER TO ACCOMMODATE PROPOSED
TELSTRA W&B HYBRID CABLES (3 OFF)

PROPOSED TELSTRA CABLE DRAW PIT

- ▽ E.L. 32.0m (±100mm) RL ~+80.0m

PROPOSED OVER ALL HEIGHT
- ▽ E.L. 31.6m (±100mm) RL ~+79.6m

C/L PROPOSED TELSTRA PANEL ANTENNAS (3 OFF, A4, A5 & A6)
- ▽ E.L. 31.0m (±100mm) RL ~+79.0m

C/L PROPOSED TELSTRA W&B JUNCTION BOXES (3 OFF)
- ▽ E.L. 30.2m (±100mm) RL ~+78.2m

C/L PROPOSED TELSTRA PANEL ANTENNAS (3 OFF, A7, A8 & A9)
- ▽ E.L. 28.9m (±100mm) RL ~+76.9m

C/L PROPOSED TELSTRA FILTERS (3 OFF)

C/L PROPOSED TELSTRA RRU's (3 OFF)
- ▽ E.L. 27.8m (±100mm) RL ~+75.8m

C/L PROPOSED TELSTRA PANEL ANTENNAS (3 OFF, A1, A2 & A3)

C/L PROPOSED TELSTRA RRU's (3 OFF)
- ▽ E.L. 26.0m (±100mm) RL ~+74.0m

TOP OF PROPOSED TELSTRA MONOPOLE
- ▽ E.L. 25.0m (±100mm) RL ~+73.0m

C/L PROPOSED CITY COUNCIL FLOOD LIGHTS

▽ E.L. 12.0m (±100mm) RL ~+60.0m
C/L RELOCATED CITY COUNCIL SECURITY CAMERA (1 OFF) (BEHIND)

▽ E.L. 4.0m (±100mm) RL ~+52.0m
C/L RELOCATED CITY COUNCIL SECURITY CAMERA (1 OFF) (BEHIND)

▽ E.L. 0.0m (±100mm) RL ~+48.0m
GROUND LEVEL

PROPOSED MONOPOLE FOOTING
SHOWN INDICATIVELY ONLY

ACRONYMS LEGEND

ODU's OUTDOOR UNITS
RRU's REMOTE RADIO UNITS

SERVICES LEGEND

EA TELSTRA EARTHING CABLE
FE BELOW GROUND FEEDER CABLES

SOUTH ELEVATION

SCALE 1:125
2m 0 5m SCALE 1:125

UNAPPROVED
DRAWING

PRELIMINARY


ORDER	DRAWN	CHKD	AMENDMENT	EXAM	APPD	DATE	ISS
VT24004.01	JM	FM	PRELIMINARY - SP80005940WO051DOWN	BS	BG	18.12.25	1



MOBILE NETWORK SITE 24902
GLEN IRIS WEST
SOUTH ELEVATION
83-141 BURKE RD, MALVERN EAST, VIC 3145

DWG NO. V116369 SHT NO. S3

 © Telstra Limited ACN 086 174 781 All rights reserved.



Downer
Relationships creating success